


SAMPLE PROJECT — GROUND FLOOR ELECTRICAL LAYOUT

Drawing No: E-101 Rev: A Scale: NOT TO SCALE (sample)

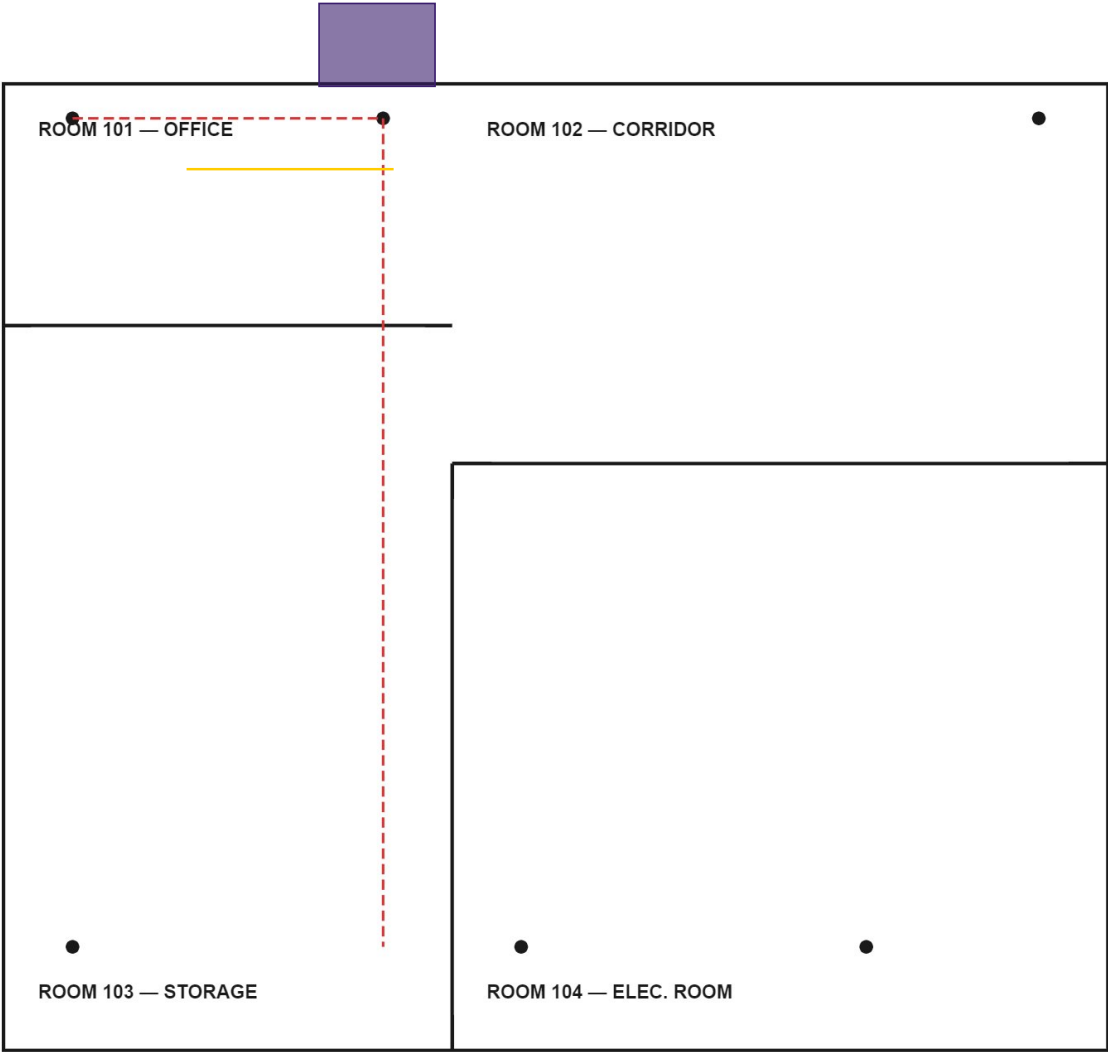

DETAIL A — PANEL SCHEDULE AREA (LARGER SCALE)

